


Firearms Complex Cheltenham, MD

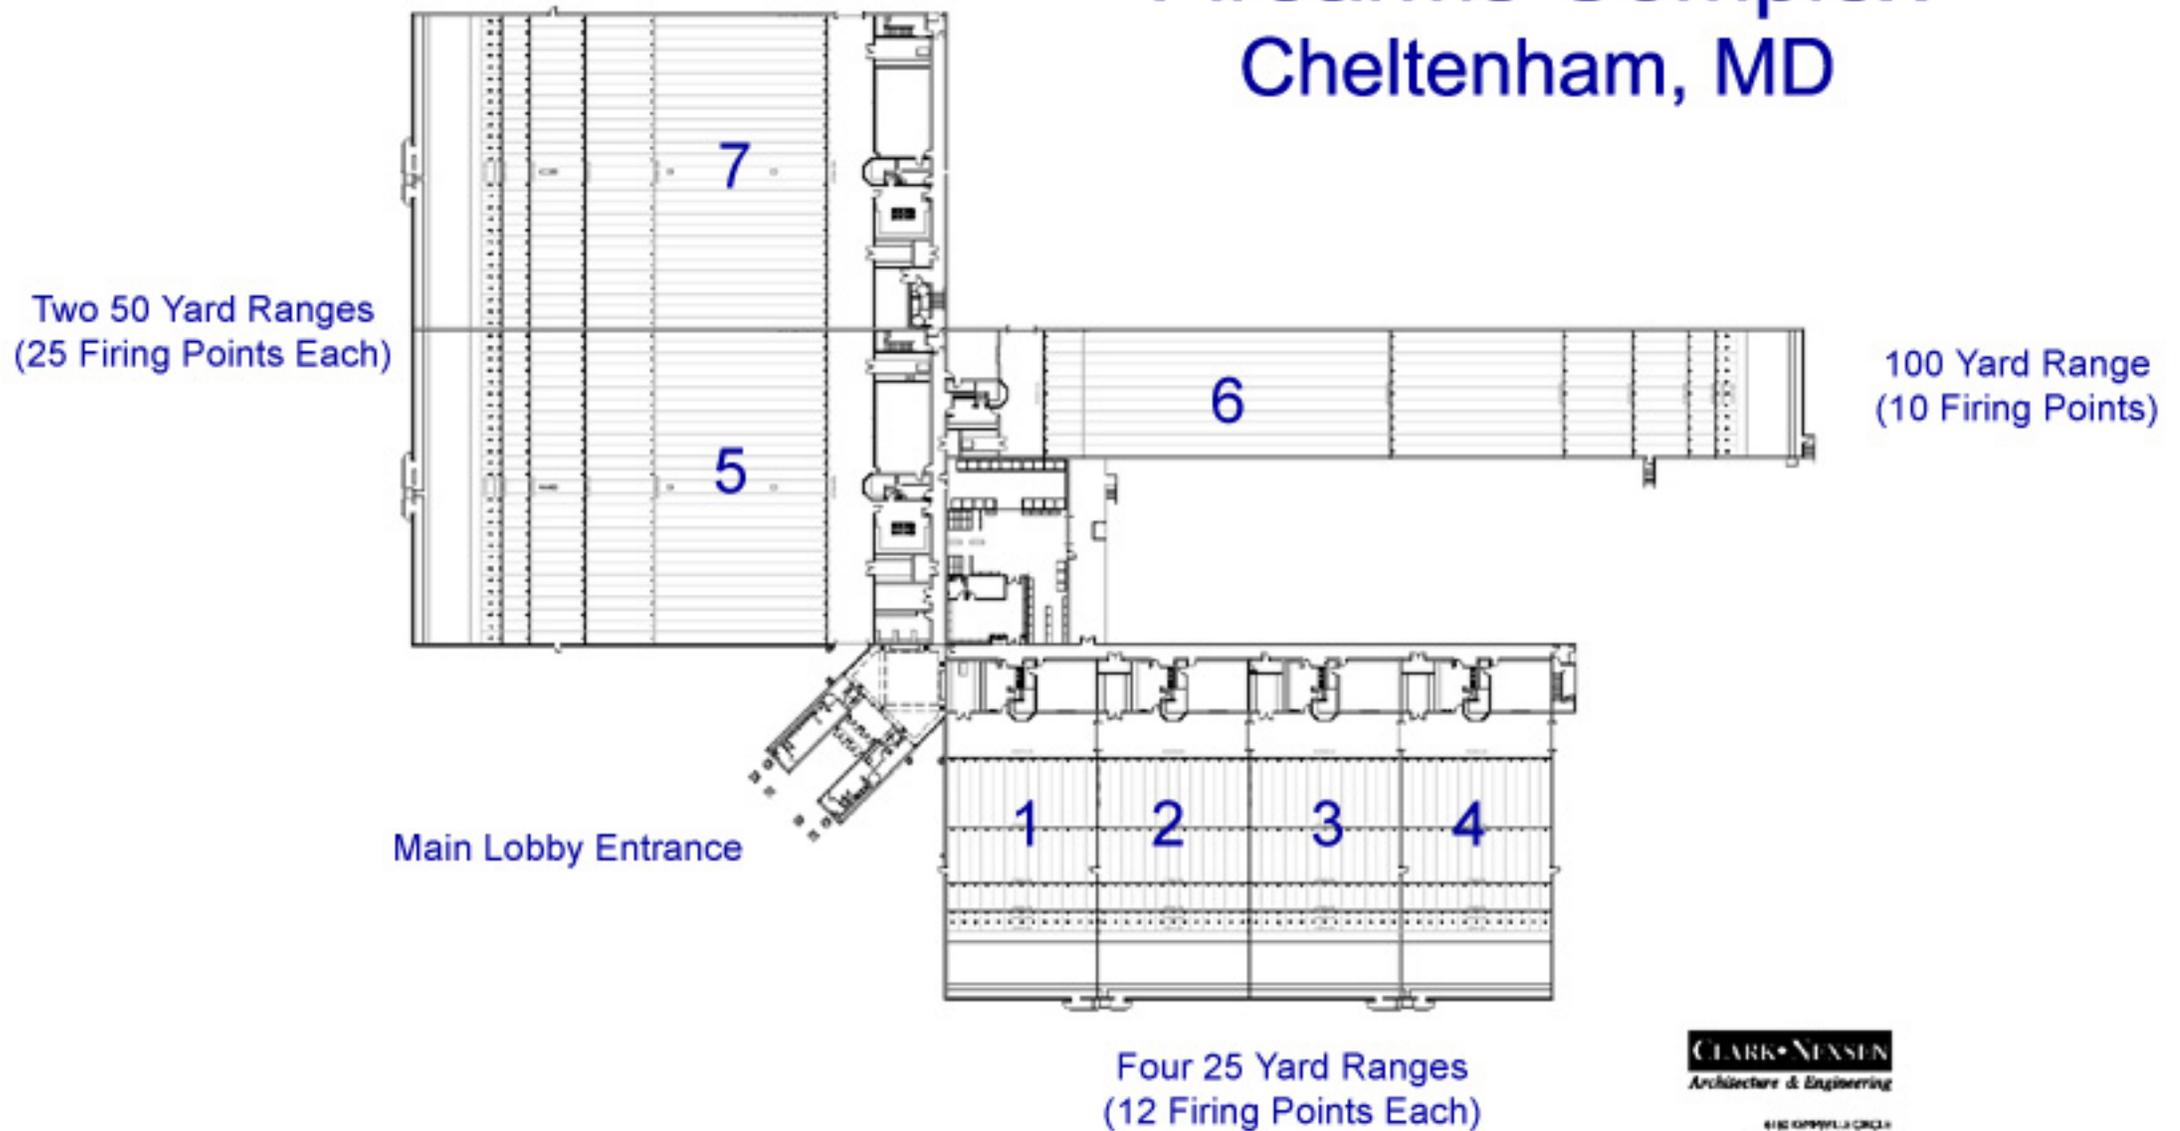

OVERALL FLOOR PLAN

SCALE: 1/32" = 1'-0"

CLARK • NIXSEN
Architects & Engineers

6180 KIPPWELL CIRCLE
NORFOLK, VIRGINIA 23502
757-635-8800 FAX 757-635-5400
WWW.CLARKNIXSEN.COM